

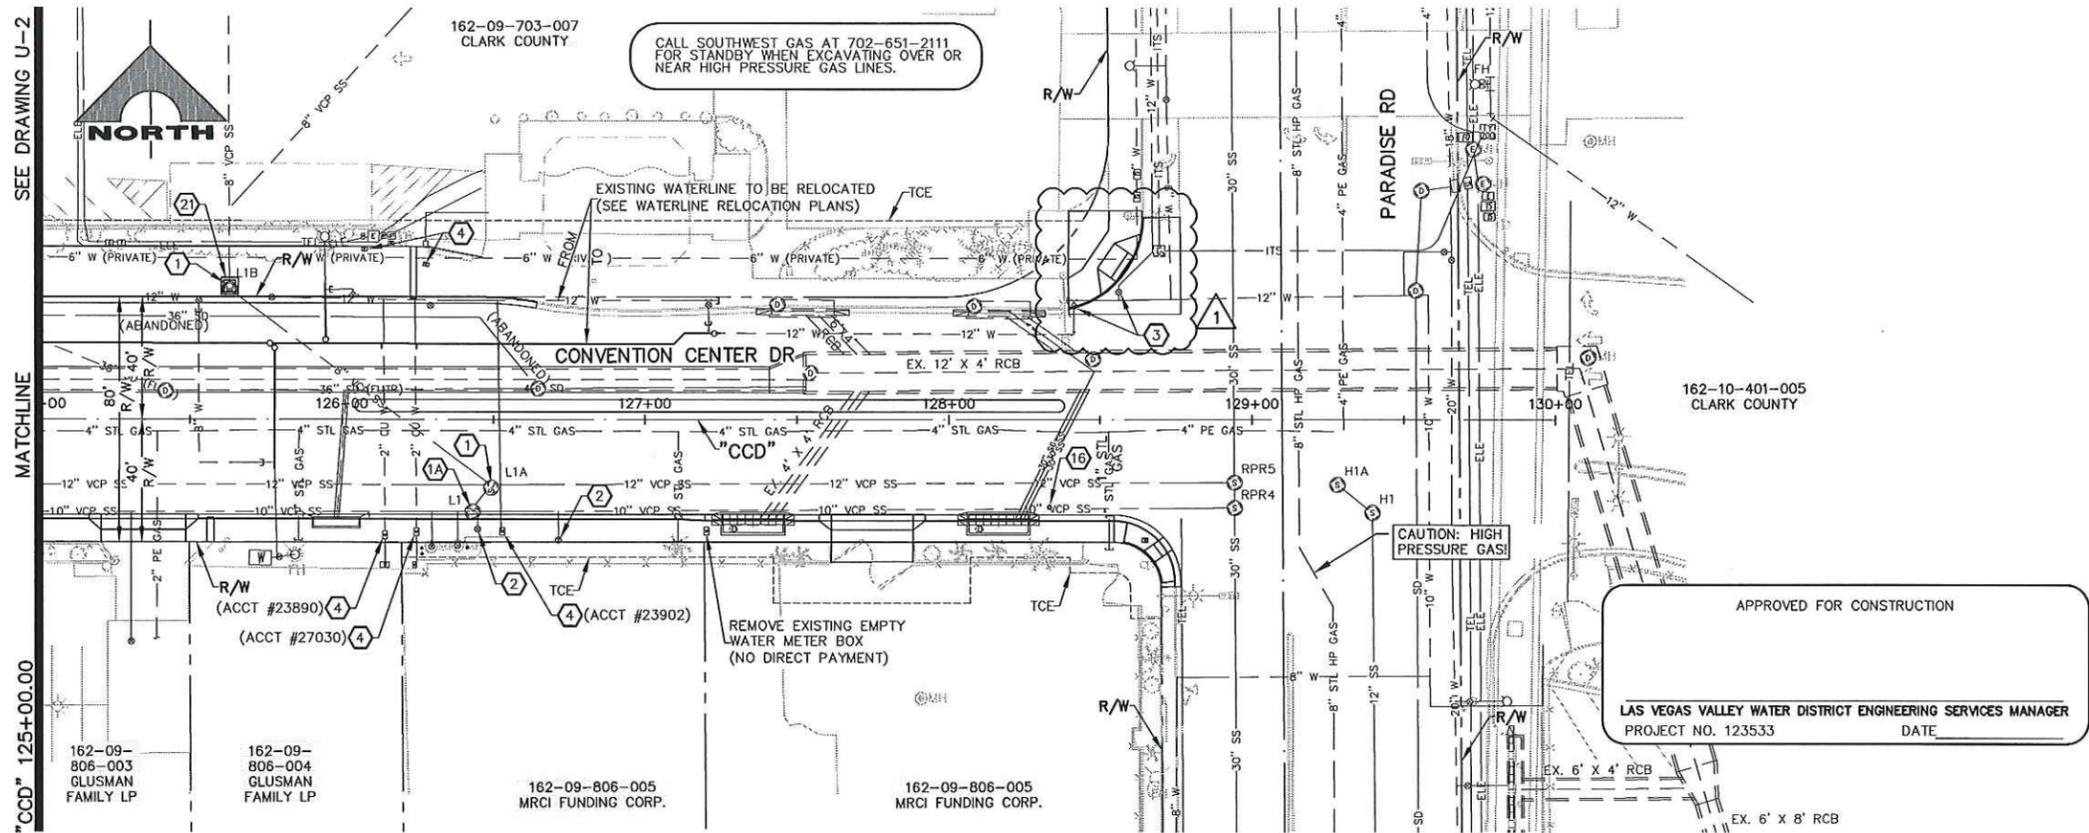


F:\Projects\60016-04-03\DWG\Production\CCD\_32-34\_U-01-03.dwg, 6/12/2015 4:40:47 PM, hschlierkamp

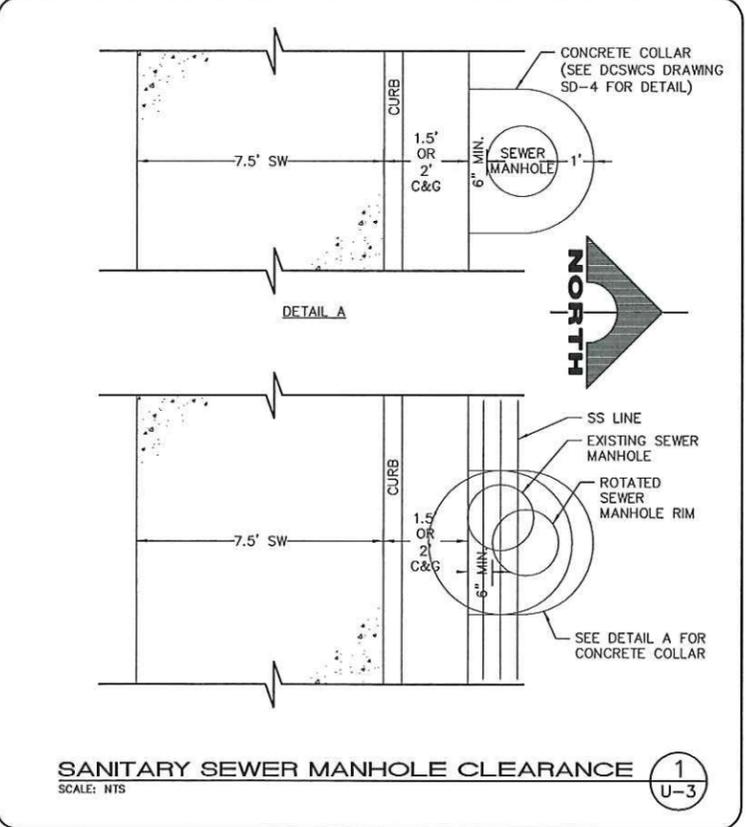

- ### UTILITY NOTES
- ① ADJUST SANITARY SEWER MANHOLE TO GRADE (DCSWCS DRAWINGS SD-2, SD-4, AND SD-5)
  - ② ADJUST SANITARY SEWER MANHOLE TO GRADE, ROTATE MANHOLE RISER CONE, GRADE RINGS, FRAME, AND COVER 90 DEGREES NORTH (SEE DETAIL 1, DRAWING U-3)
  - ③ ADJUST SANITARY SEWER CLEAN-OUT TO FINISH GRADE (DCSWCS DRAWING SD-26)
  - ④ ADJUST WATER VALVE BOX COVER TO GRADE (UDACS PLATE NO. 39)
  - ⑤ ADJUST WATER METER TO FINISH GRADE (UDACS PLATE NO. 4)
  - ⑥ ADJUST WATER VAULT TO FINISH GRADE
  - ⑦ ADJUST TELEPHONE MANHOLE TO FINISH GRADE (BY CENTURY LINK)
  - ⑧ ADJUST TELEPHONE PULLBOX TO FINISH GRADE (BY CENTURY LINK)
  - ⑨ ADJUST CABLE TV PULLBOX TO FINISH GRADE (BY COX)
  - ⑩ ADJUST CABLE TV VAULT TO FINISH GRADE (BY COX)
  - ⑪ ADJUST GAS VALVE TO FINISH GRADE (BY SOUTHWEST GAS CONTRACTOR, IF FOUND)
  - ⑫ ADJUST GAS RECTIFIER STATION AT SOUTHWEST GAS DISCRETION (BY SOUTHWEST GAS CONTRACTOR)
  - ⑬ RELOCATE ELECTRIC MANHOLE TO FINISH GRADE (BY NV ENERGY)
  - ⑭ ADJUST ELECTRIC VAULT TO FINISH GRADE (BY NV ENERGY)
  - ⑮ ADJUST ELECTRIC PULLBOX TO FINISH GRADE (BY NV ENERGY)
  - ⑯ ADJUST RTC TICKET VENDING MACHINE (BY RTC)
  - ⑰ ADJUST MONITOR WELL TO FINISH GRADE
  - ⑱ PROTECT FIRE HYDRANT IN PLACE, INSTALL PAD (UDACS PLATE NO. 40)
  - ⑲ EX. SWG 2" PVC CONDUIT WITH ELEC SERVICE PROTECT-IN-PLACE
  - ⑲ EX. SWG 2" PVC CONDUIT WITH ANODE BED CABLES. HAND DIG, MUST BE PROTECTED-IN-PLACE. USE EXTREME CAUTION!
  - ⑲ EX. SWG ANODE BED WELL. HAND DIG, MUST BE PROTECTED-IN-PLACE. USE EXTREME CAUTION!
  - ⑳ INSTALL SEWER ACCESS DOOR (SEE DETAIL 2, DRAWING U-3)

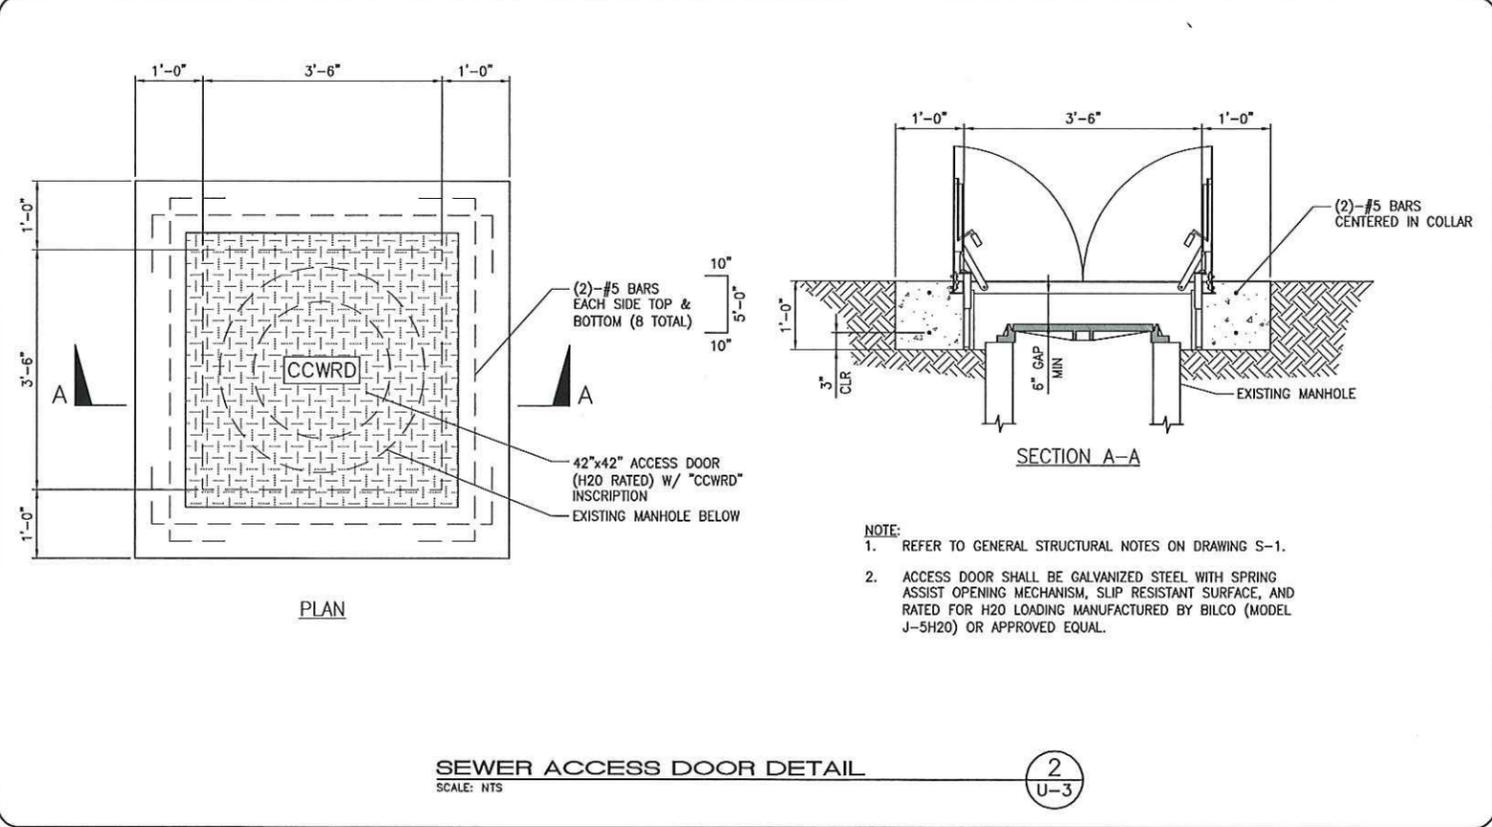


**CLARK COUNTY WATER RECLAMATION DISTRICT**

BY \_\_\_\_\_ DATE \_\_\_\_\_

CCWRD PROJECT CONTROL NUMBER IS **8724.12**

SIGNATURE ON THESE PLANS SHALL NOT BE CONSTRUED TO BE A PERMIT FOR OR AN APPROVAL OF ANY VIOLATION OF CLARK COUNTY WATER RECLAMATION DISTRICT RULES, REGULATIONS, OR DESIGN AND CONSTRUCTION STANDARDS. THE APPROVAL OF THESE DRAWINGS DOES NOT GUARANTEE CAPACITY IN THE DISTRICT'S COLLECTION OR TREATMENT SYSTEM.

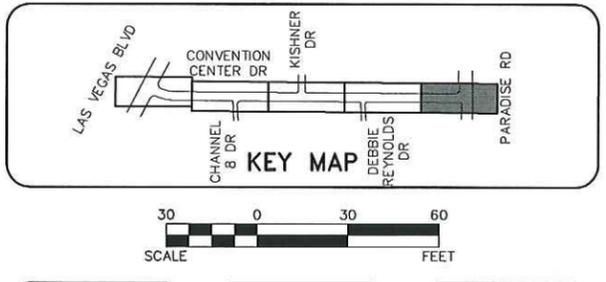

AVOID HITTING OVERHEAD POWER LINES IT'S COSTLY!

**CALL-BEFORE-YOU-DO-OVERHEAD**

1-702-227-2929

Call before you Dig

Avoid cutting underground utility lines. It's costly.

**Call 811**

OR 1-800-227-2600

**FAST**

Call before you UnderGround.

1-702-432-5300

FREEWAY AND AIRTEL SYSTEMS OF TRANSPORTATION

REV. NO.	DATE	DESCRIPTION	APPROVED
1	6/12/15	ADDENDUM NO. 1 - ADDED VALVE ADJUSTMENT	WLF

**CLARK COUNTY NEVADA**

## CONVENTION CENTER DRIVE - LAS VEGAS BLVD TO PARADISE RD

### UTILITY PLAN

"CCD" 125+00.00 TO "CCD" 131+09.77

CLARK COUNTY, NEVADA, DEPARTMENT OF PUBLIC WORKS

PROJECT No: 640-043 DRAWN BY: TJC

DESIGNED BY: WLF CHECKED BY: SRP

APPROVED BY: \_\_\_\_\_

SCALE		DRAWING NO.
HORIZ: AS SHOWN		U-3
VERT: NONE		SHT. 34 OF 41
FIELD BOOK		L-2097

**G. C. WALLACE COMPANIES**  
ENGINEERS | PLANNERS | SURVEYORS  
1555 S. RAINBOW BLVD. LAS VEGAS, NV 89146  
T: 702.804.2000 F: 702.804.2299 GCWALLACE.COM